

SYMBOL

\$ мѕ

-**-**

DESCRIPTION

SAME AS ABOVE, W/ 2 BULBS WIRED FOR NIGHT LIGHT AND 2 BULBS TO SWITCH, MINI, 4HRS POWER BATTERIES BACKUP,

COOPER LIGHTING-METALUX 8T=8' LENGTH YT2=YAPOR TILE 32W, 2TTY, W/6 LAMP6 UNY,

'SURE-LITES' EXIT LIGHT, UN SERIES
W/ POWER PACK W/90 MIN

'SURE-LITES' EMERGWENCY LIGHT PLB SERIES W/ POWER PACK W/30 MIN

RECESSED CANS, 40W,2TTV,IP 6 INCH DOWNLIGHT BLACK BAFFLE/ WHITE IC: 26W/32W TRIPLE CFL.TC: 26W/32W TRIPLE TUBE CFL.

T.C. TIMER CONTROL 24 HRS, T DAYS WITH E. BATTERY BACKUP POWER FOR

SWITCHES- WITH REMOTE CONTROL DEVICE CS 20-WAND INDICATOR PILOT LIGHT, WITH 30 MIN AUTO OFF 4 INTEGRATED MOVEMENT SENSOR.

DROP DOWN PENDENT LIGHTS, 40W,277V,IP

2x4' RECESSED FLUORESCENT LIGHT FIXTURES WHITEWAY MODEL 3RF-48P (3 LAMPS)2TIV, IOOW (32W EA.) OR EQUAL. PROVIDE FLASTIC SHIELD IN KITCHEN AND FOOD PREPERATION AREAS

224' RECESSED FLUORESCENT LIGHT FIXTURES WHITEWAY MODEL 3RF-48P (3 LAMPS)2TTV, IOOW (32W EA.) SURFACED MOUNTED FIXTURES.

MANUF.

COOPER LIGHTING

SURE LITES

SURE LITES

SUBMITTAL REQUIRED

SUBMITTAL REQUIRED


SUBMITTAL REQUIRED

GLASS BEZELS BY OWNER LIGHT FIXTURE SUBMITTAL REQUIRED

COUNT ORDER FROM NOTES

SUBMITTAL REQUIRED

RECESSED FLUORESCENT FIXTURE

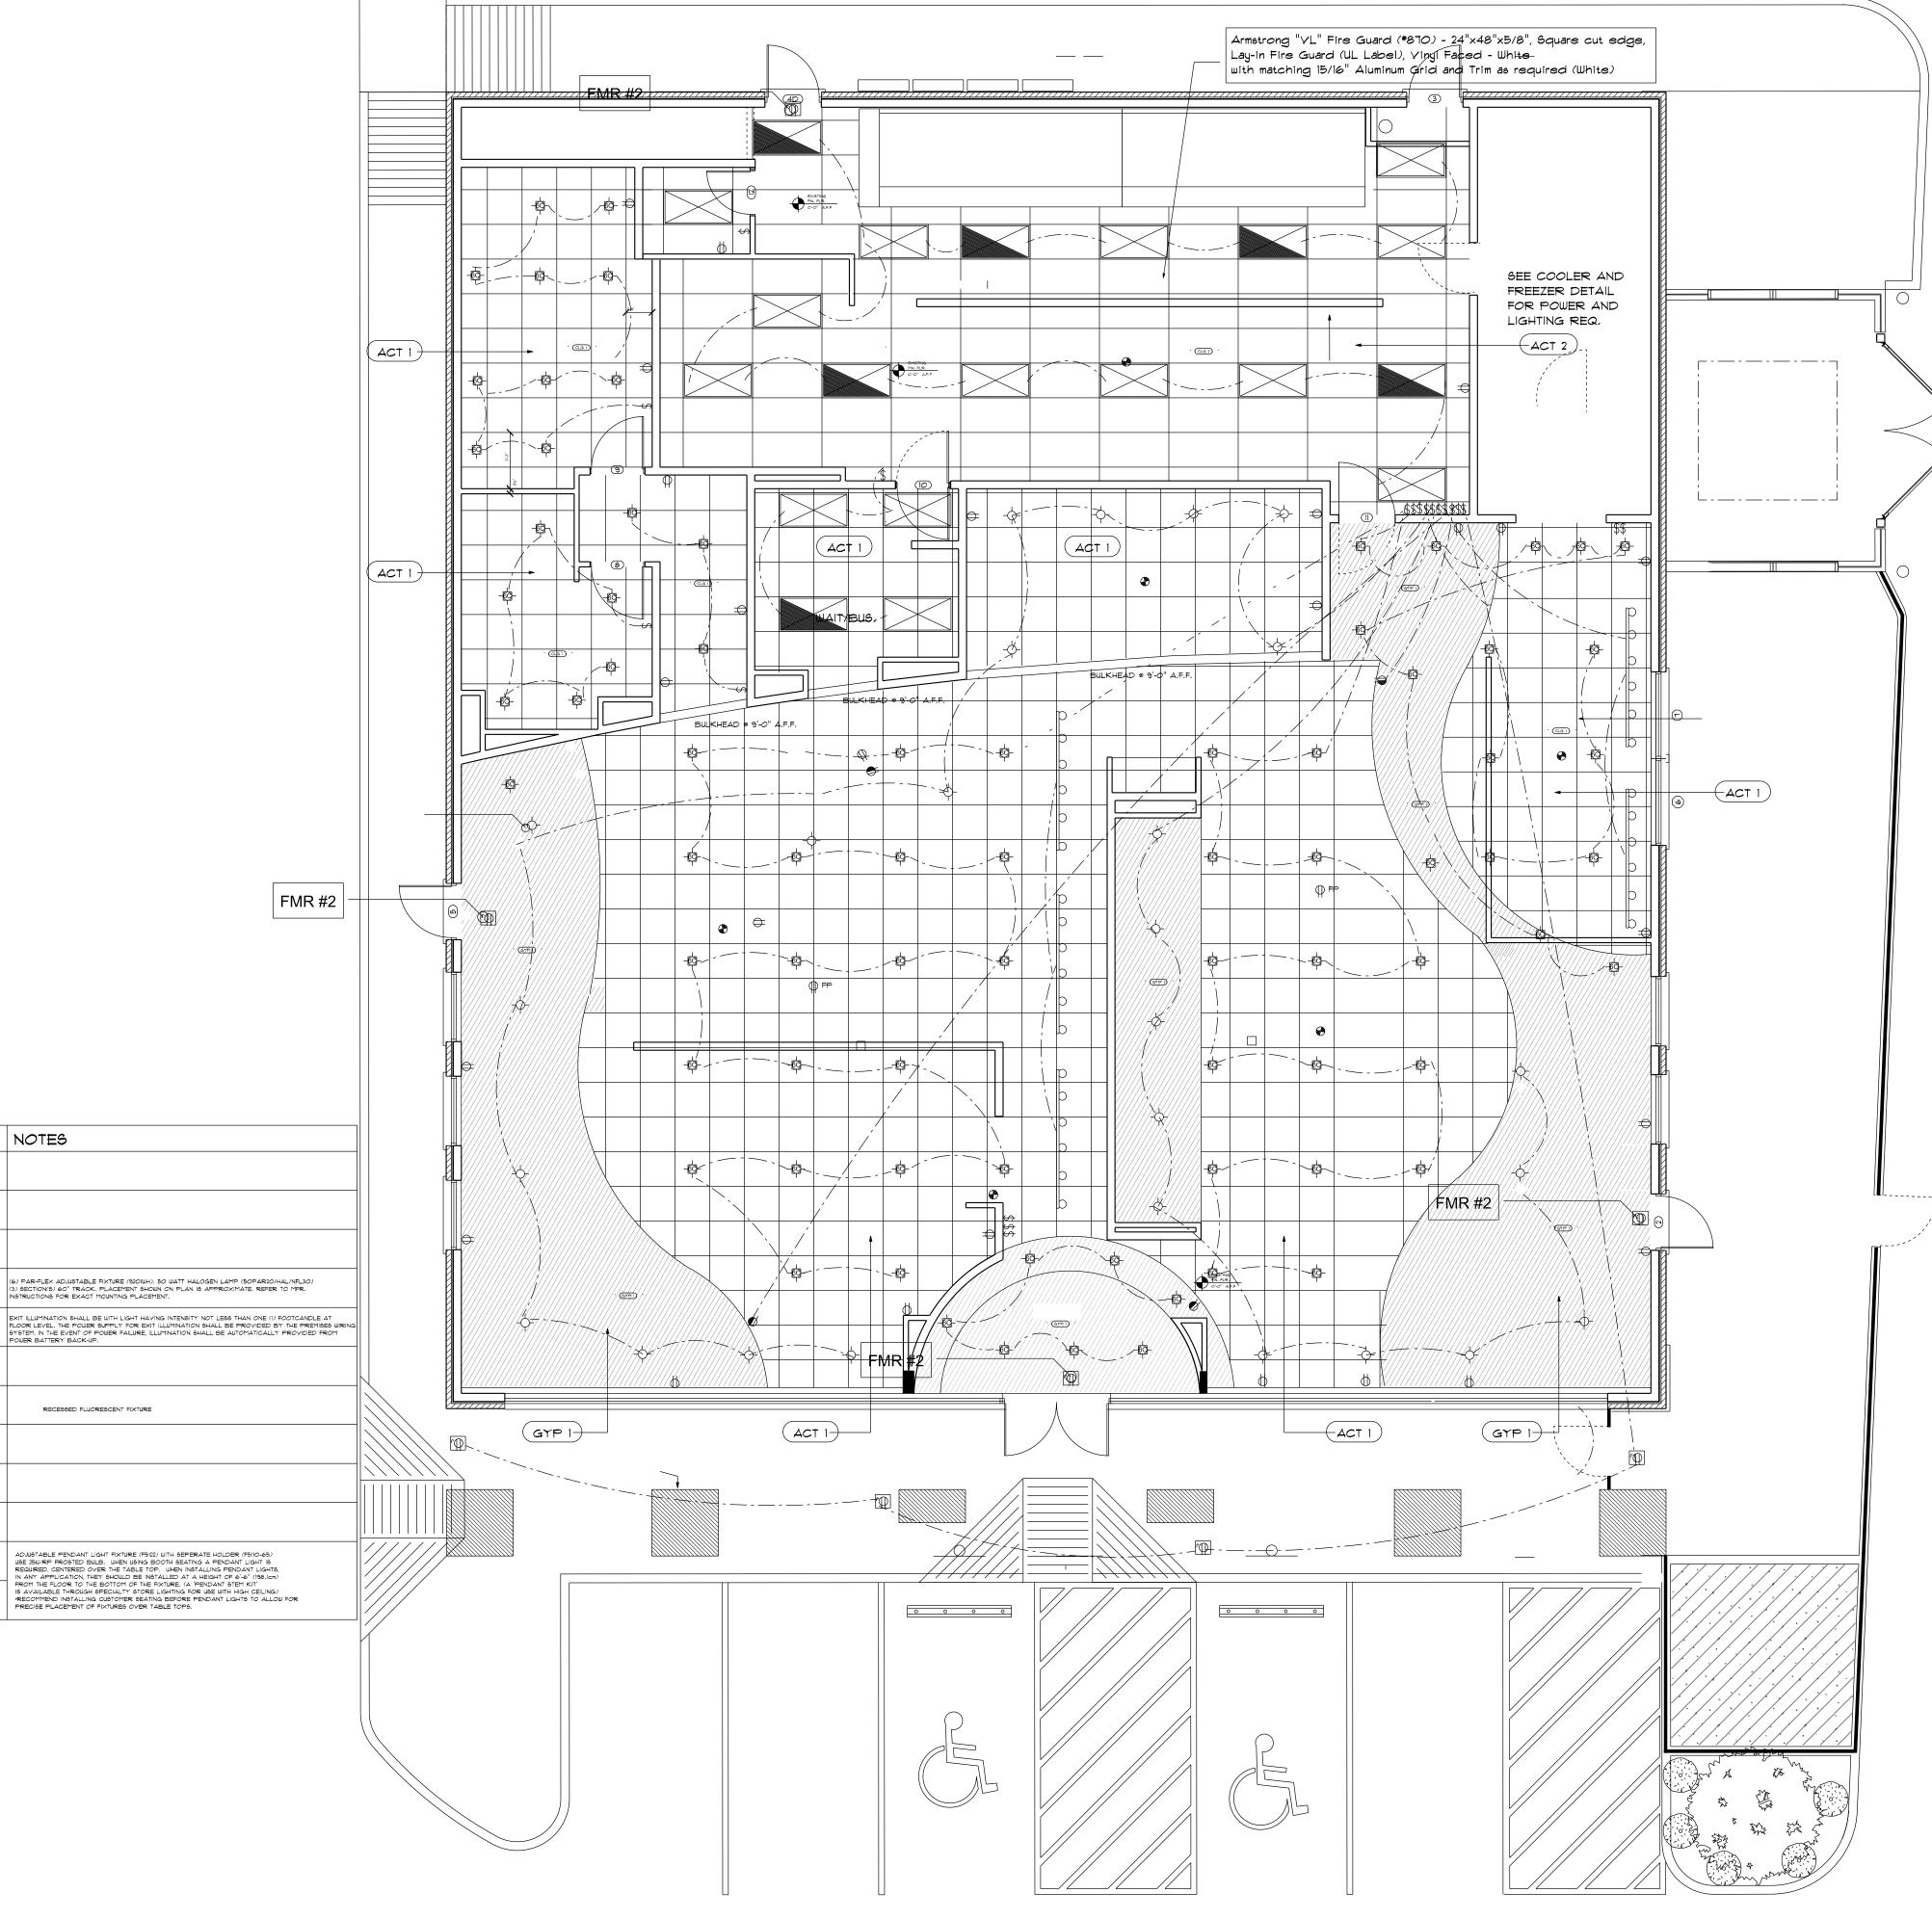

| FIRST FLOOR AREA | 5,250 SQ. FT. |
|------------------|---------------|
| PATIO AREA       | 860 SQ. FT.   |
| MEZZANINE        | 613 SQ. FT.   |
| TOTAL AREA       | 6,723 SQ. FT. |

| DINING      | 187 |  |
|-------------|-----|--|
| PATIO       | 38  |  |
| TOTAL SEATS | 225 |  |

FMR #1

MAIN FLOOR LAYOUT SCALE: 3/16" = 1'-0"

(P) 713.680.1333 (F) 713.680.1334

3301 Edloe Suite 100 Houston TX 77027



DO NOT SCALE DRAWINGS CONTRACTOR TO VERIFY ALL EXISTING CONDITIONS AND DIMENSIONS-NOTIFY DESIGNER OF ANY DESCREPANCIES PRIOR TO BEGINNING CONSTRUCTION.

| VERSION ID    | DATE     |
|---------------|----------|
| PERMIT REVIEW | 09/21/10 |
|               |          |
|               |          |
|               |          |
|               |          |
|               |          |

PROJECT NUMBER FCF5625 AS NOTED SHEET ID SWITCHING AND LIGHTING LAYOUT SHEET NUMBER

PROPERTY OF GENE GILES ANY UNAUTHORIZED PROPERTY OF GENE GILES ANY UNAUTHORIZED COPIES OR DISTRIBUTION IS A VIOLATION OF FEDERAL COPYRIGHT LAW AND SUBJECT TO PROSECUTION UNDER THE GUIDELINES OF THE FEDERAL COPYRIGHT ACT

C:\Users\Gene Giles\Desktop\Roadwork\Don Julios's Sienna\Final\

ISSUE DATE - 5-26-2010 PRINT DATE 9-21-2010