## ELECTRICAL PLAN NOTES

E.C. TO COORDINATE WITH MECHANICAL CONTRACTOR FOR ELECTRICAL REQUIREMENTS FOR HEATING AND COOLING EQUIPMENT.

E.C. TO COORDINATE WITH PLUMBING CONTRACTOR FOR HOT WATER

HEATER ELECTRICAL REQUIREMENTS.

ALL DEVICE AND COVERPLATE ASSEMBLIES SHALL BE COLOR: FILL IN

DEVICES SHOWN SIDE-BY-SIDE SHALL BE MOUNTED STRAIGHT, LEVEL, AND AS CLOSE TOGETHER AS POSSIBLE ON THE HORIZONTAL PLANE.

DEVICES SHOWN "STACKED" SHALL BE MOUNTED STRAIGHT, LEVEL, AND ALIGNED VERTICALLY AT 15" A.F.F., U.N.O.

VERIFY SWITCHING WITH TENANT, U.N.O..

ALL LIGHT SWITCHES SHALL BE INSTALLED NO MORE THAN 6" FROM ROUGH OPENING OF DOOR, U.N.O.

G.C. TO COORDINATE EXACT LOCATION OF ALL ELECTRICAL DEVICES W/FIELD DIMENSIONED CASEWORK SHOP DRAWINGS. ANY DISCREPANCIES ARE TO BE BROUGHT TO THE ATTENTION OF THE ARCHITECT PRIOR TO INSTALLATION OF ELECTRICAL DEVICES.

6 VERIFY LOCATION WITH ARCHITECT

(7) ELEVATOR ELECTRICAL TYPICAL:

ONE 240 VOLT 30 AMP DEDICATED SERVICE 10-3 WIRE WITH GROUND IN 4X4 ELECTRICAL BOX AND ONE 120 VOLT, 20 AMP SERVICE IN 4X4 ELECTRICAL BOX, TELEPHONE LINE, GFI RECEPTACLE, LIGHT FIXTURE WITH BULB GUARD AND SWITCH, SHALL ALL BE LOCATED IN ELEVATOR HOISTWAY OVERHEAD OR IN ATTIC DEPENDING ON LOCATION OF ACCESS DOOR.

## 2-Outlet / Switch Detail

FIELD OUT FOR-

R-CONTROL-

ZEXTERIOR FINISH

**& UNDERLAYMENT** 


AS REQ'D BY

CODE.

ELECTRICAL BOX.

PROVIDED ELEC.

FACTORY

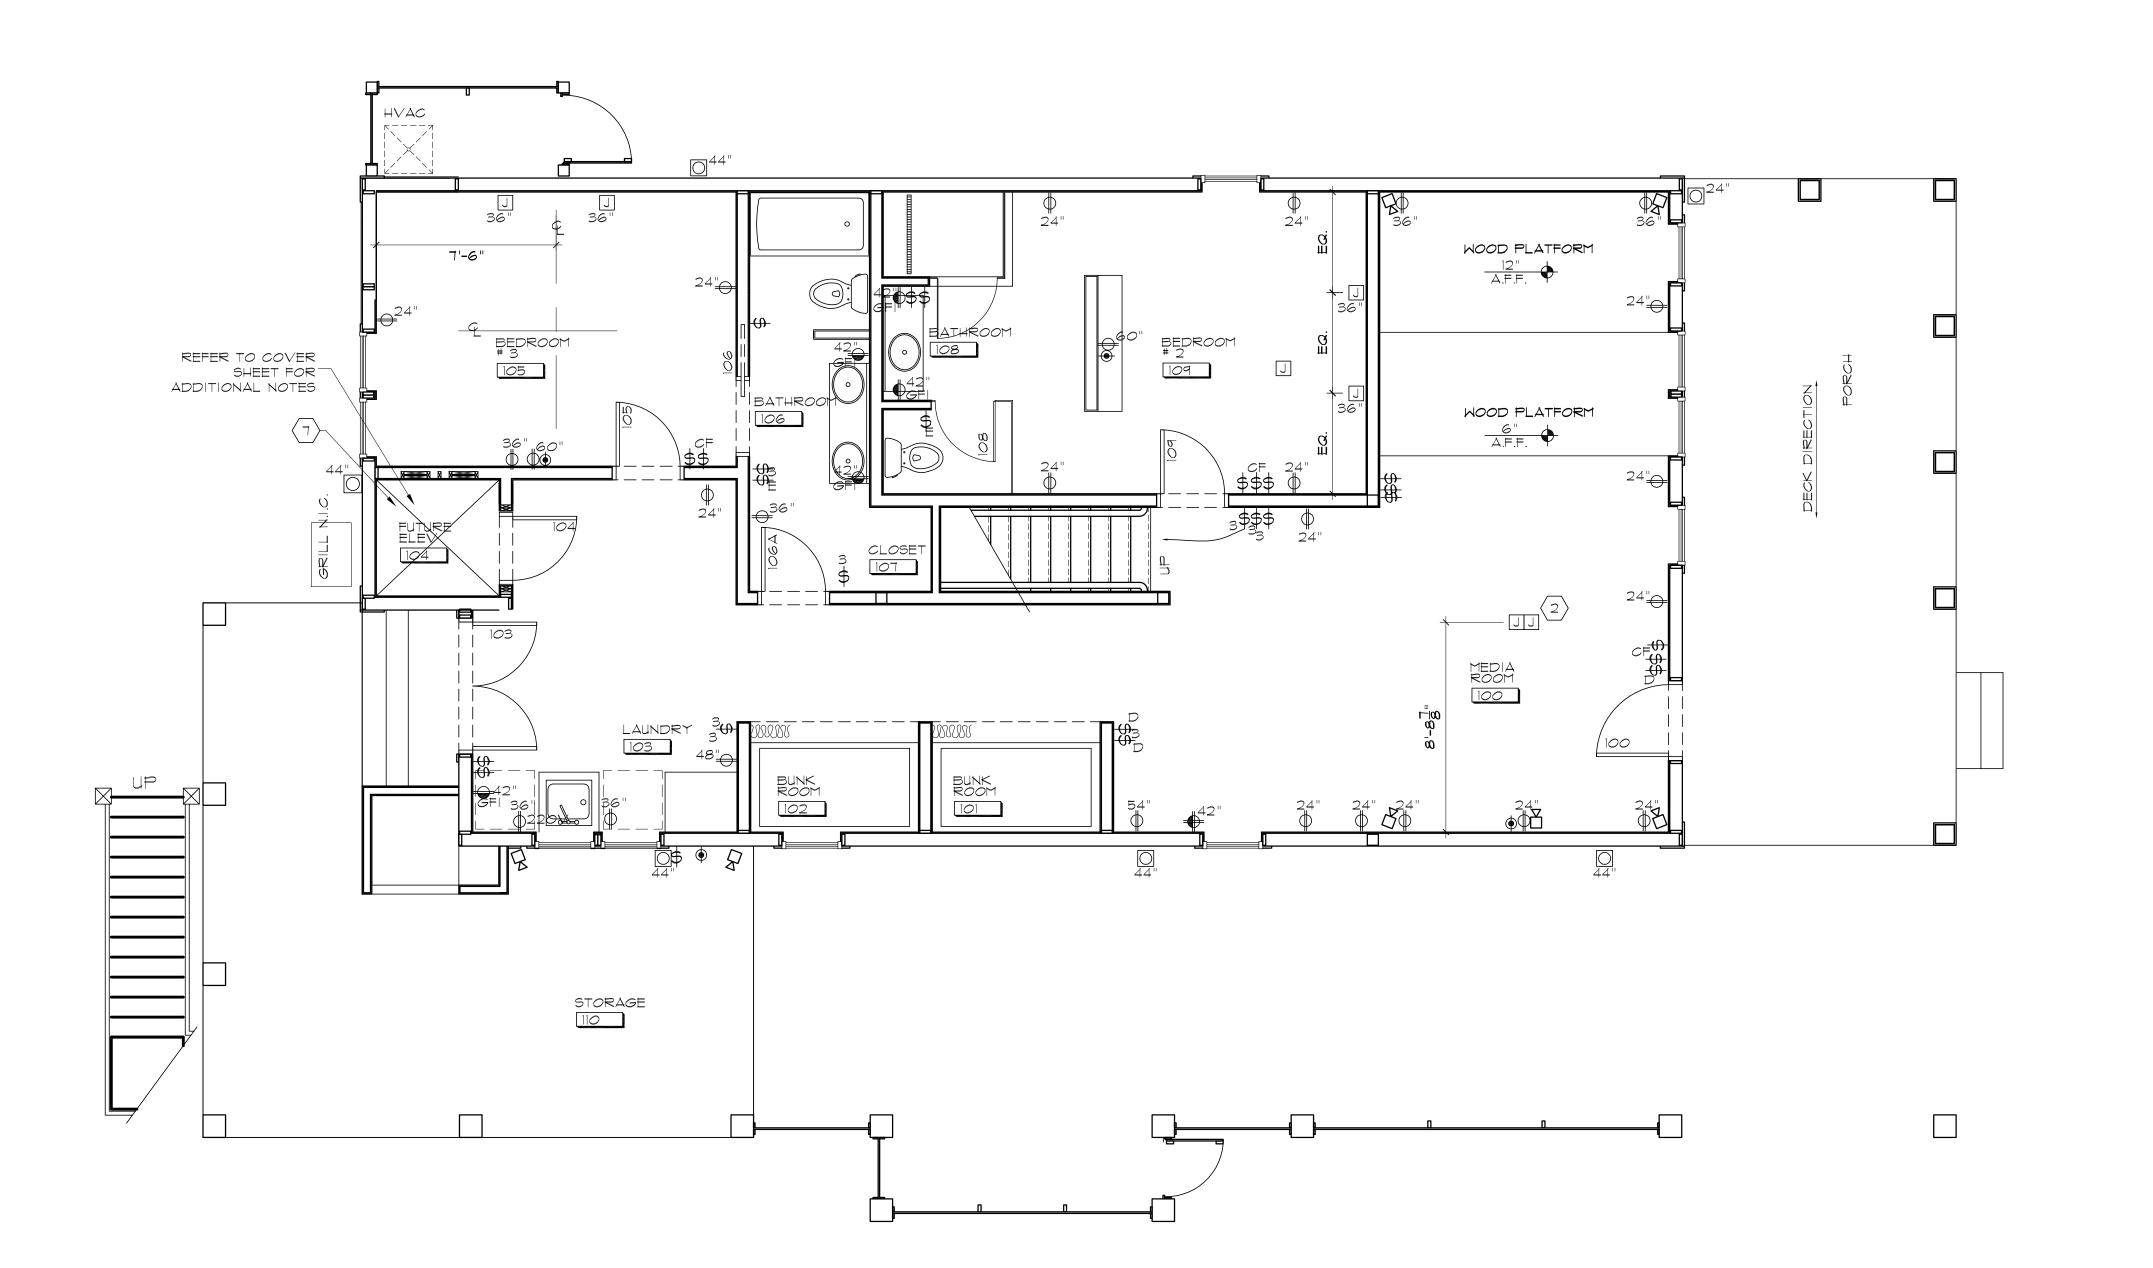

## GROUND LEVEL ELECTRICAL PLAN Scale: 1/4"=1'-0"



## Electrical Legend

ROOM NAME

201 ROOM NAME & NUMBER

6 PLAN NOTE

SINGLE ELECTRICAL OUTLET, 220/230 VOLTS.

DUPLEX ELECTRICAL OUTLET, 110/120 VOLTS.

DUPLEX ELECTRICAL OUTLET, GFI

DUPLEX ELECTRICAL OUTLET, DEDICATED CIRCUIT.

DUPLEX ELECTRICAL OUTLET, ISOLATED GROUND CIRCUIT.

QUAD ELECTRICAL OUTLET

QUAD ELECTRICAL OUTLET, DEDICATED

QUAD ELECTRICAL OUTLET ISOLATED GROUND

QUAD ELECTRICAL OUTLET, GFI

FLOOR MOUNTED OUTLET

MULTIPLE OUTLET/PLUG MOLD

GROUND FAULT INTERRUPTER

INDICATED MOUNTING HEIGHT ABOVE FINISHED FLOOR

OUTDOOR WALL MOUNTED DUPLEX ELECTRICAL OUTLET, GFI

\$ ONE WAY SWITCH

3 THREE WAY SWITCH

\$4 FOUR WAY SWITCH

\$ INDICATES SWITCH W/ DIMMER

FIXTURES GANGED BY AREA

INDICATES FIXTURE TO BE SWITCHED

CABLE OR SAT. TV

THERMOSTAT. VERIFY EXACT LOCATION & HEIGHT WITH ARCHITECT PRIOR TO INSTALLATION.

ELECTRICAL METER

J PROVIDE JUNCTION BOX

SURFACE MOUNTED ELECTRICAL PANEL & CABINET

HOT WATER HEATER

• BELL

BUZZER

SPEAKER @ 7'-0" AFF.

HE GRUENE F

RED 490 THE BOARD THE CINNA ST250 THE ST250 TH

620 N. Delaware Indianapolis, IN 46204 317.262.1220 tel 317.262.1260 fax

SRENNER DESIGN
Architecture
interiors

