

48" FLUORESCENT LICHT

D Z

23R

8 တ

94

ELECTRICAL (FOR SHEET E2.01) KEYED NOTES:

- $\stackrel{\textstyle (1)}{}$ 277/4808V., 3ø, 4W PANELBOARD <u>HA</u>. REFER TO SHEET E4.00 FOR PANEL SCHEDULE INFORMATION.
- 120/208V., 3ø, 4W PANELBOARD $\underline{\mathsf{LA}}.$ REFER TO SHEET E4.00 FOR PANEL SCHEDULE INFORMATION.

<u>N</u>

VOLTS

PH.

LOAD

LOC.

CONN.

REMARKS

ISSUE 11-30-10

ISSUED FOR PERMIT

/30/2010

ELECTRICAL

SCHEDULE

- 120/208V., 3ø, 4W PANELBOARD LK (2-SECTION). REFER TO SHEET E4.00 FOR PANEL SCHEDULE INFORMATION.

- 120/208V., 3ø, 4W PANELBOARD <u>CA</u>. REFER TO SHEET E4.00 FOR PANEL SCHEDULE INFORMATION.
- 480V: 120/208V, 3¢, 4W (150KVA) TRANSFORMER <u>TLA</u> MOUNTED ON ROOF. REFER TO RISER DIAGRAM ON SHEET E4.00 FOR MORE INFORMATION. LINE ENTIRE WALL WITH 3/4" THICK FIRE RETARDANT PLYWOOD TELEPHONE BACKBOARD. UTILIZE SHELL BUILDING STUB AND EXTEND (1) 1 1/2"C. FROM BUILDING TELEPHONE NETWORK DEMARCATION POINT. FIELD VERIFY EXACT LOCATION OF TELEPHONE COMPANY CABINET.

6

(7)


5

4

(3)

- ALL 15A/1P AND 20A/1P RECEPTACLES WITHIN KITCHEN AND SERVING AREAS SHALL BE GFCI PROTECTED PER NEC.
- PROVIDE EDWARDS LOW VOLTAGE PUSH BUTTON #603-L MOUNTED AT +48" A.F.G. PROVIDE EDWARDS ADAPTABUZZER "340A SERIES" WITH 24V LOW VOLTAGE TRANSFORMER. J-BOX FOR ALARM EQUIPMENT.

FACTURER. ADDITIONAL SHUN RLOCKING OF KITCHEN SUPPLY CAL PACKAGE. 3 PHASE MOTO CAL PACKAGE. RE INFORMATION. REFER TO

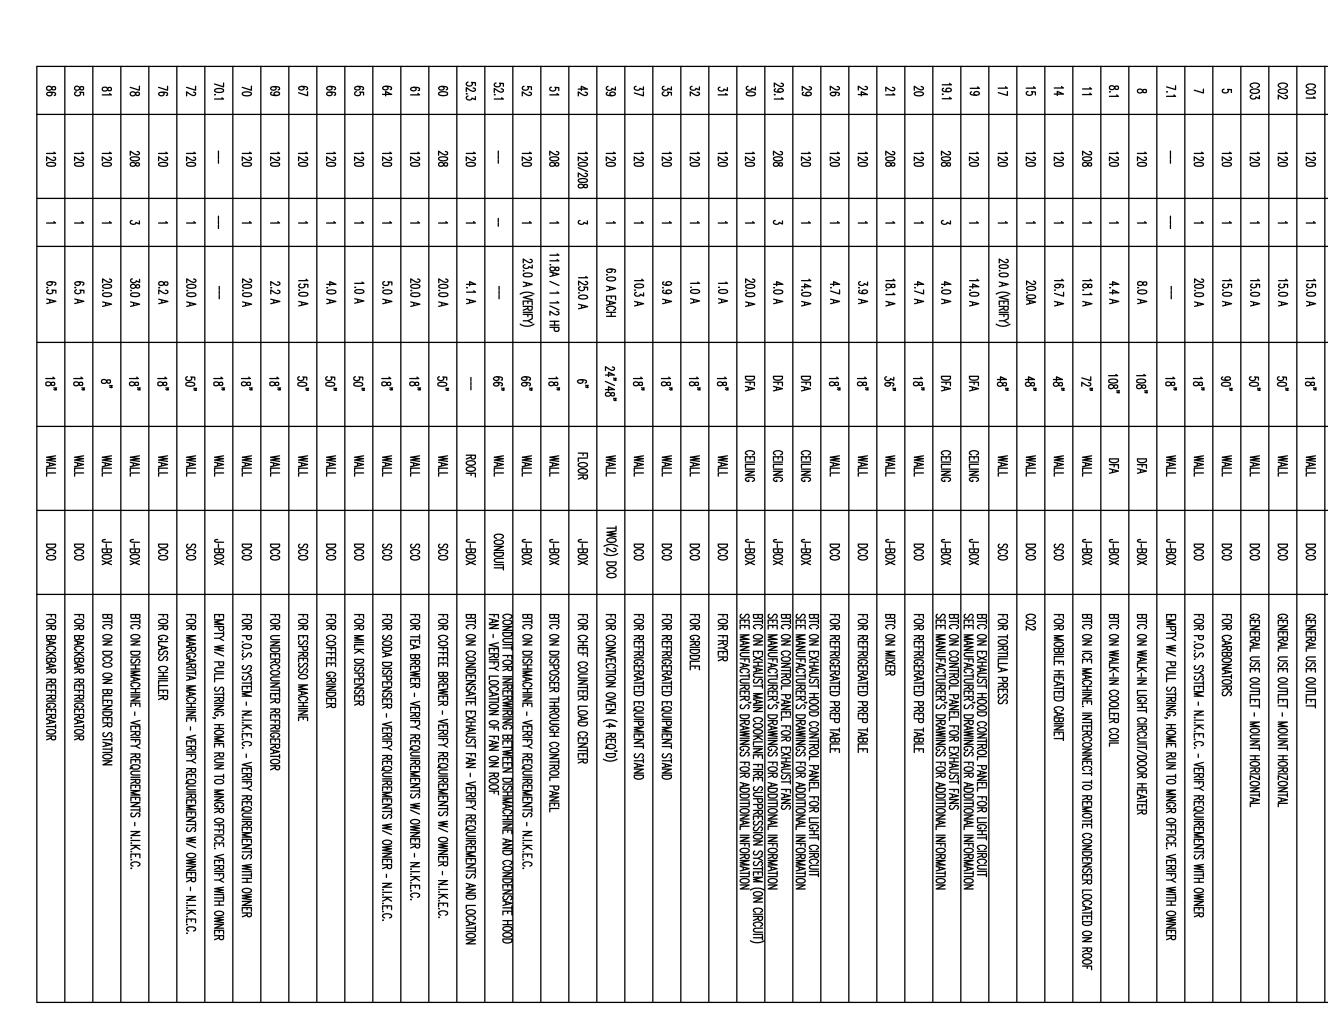

E IF ELECTRICAL OUTLETS AND/OR RECEPTACLES ARE CHANGED FROM "STUB-UP" TO "WALL-MOUNTED", THE "WALL-MOUNTED" OUTLETS AND/OR RECEPTACLES ARE TO BE SET AT 12" A.F.F.	ALL DIMENSIONS GIVEN ARE IN INCHES TO 4*-0" AND ARE FROM CENTERLINES AND/OR FINISHED WALLS. ELEVATIONS GIVEN ARE FROM FINISHED FLOOR TO CENTERLINE OF OUTLET. ALL ROUGH-INS SHOWN ARE TO BE RUN INSIDE WALLS (EXCEPT STUB-UPS). LOCATION INDICATES POINT OF EXIT FROM WALLS, CEILINGS OR FLOORS. ALL CONVENIENCE OUTLETS ARE TO SET HORIZONTALLY. ALL 120 VOLT OUTLETS NOT DESIGNATED WITH SPECIFIC LOADS TO BE RATED AT 20.0 AMPS. ELECTRICIAN TO CONNECT ALL ELECTRICAL EQUIPMENT AND FIXTURES AND DO ANY INTERNAL WIRNIG REQUIRED IN THE FIXTURES AND DO ANY INTERNAL WIRNIG REQUIRED IN THE FIXTURES AS REQUIRED BY THE SPECIFICATIONS. ALL ELECTRICIAN, AS WELL AS THE RECEPTACLE, UNLESS OTHERWISE SPECIFIED IN THE ITEM SPECIFICATIONS. ALL DISCONNECT SWITCHES ARE TO BE FURNISHED AND INSTALLED BY THE ELECTRICIAN AT TIME OF INSTALLATION. ALL WORK TO BE PERFORMED IN FULL ACCORDANCE WITH ALL APPLICABLE CODES RELATING TO HOOK-UP, INSTALLATION AND WIRING OF EQUIPMENT. OMISSIONS OR ERRORS ON THE SCHEDULE DO NOT RELIEVE THE ELECTRICIAN FROM COMPLETE FINAL CONNECTION RESPONSIBILITY.						A ALL ELECTRICAL OUTLETS SHOWN ON THIS PLAN ARE FOR FIXTURES SPECIFIED AS FURNISHED BY THE KITCHEN EQUIPMENT SUPPLIER. FOR FURTHER BUILDING ELECTRICAL REQUIREMENTS (TELEPHONES, CLOCKS, SIGNS, ETC.) SEE OTHER PLANS			ELECTRICAL NOTES					
		EL	•	Ó	₩		-	-	Ф	١	Φ	•	0	<u></u>	
		ELEVATION ABOVE FINISHED FLOOR	HEATING ELEMENT	MOTOR	SWITCH AS NOTED	Breaker Panelboard	LIGHT INDICATION	SINGLE POWER OUTLET (208)	OUTLET (SCO)	SINICI E CONVENIENCE	DUPLEX CONVENIENCE	STUB-UP	CONDUIT	JUNCTION BOX (J-BOX)	ELECTRICAL SYMBOLS/ABBREVIATIONS
		KES	8	KW	₩	SU		втс	DFA	AFF	뫋	W	٧	Α)LS/
				1	HORSE POWER	FINISHED FLOOR	٦	BRANCH TO CONNECTION POINT AND CONNECTION	DOWN FROM ABOVE	above finished floor	PHASE	WATTS	VOLTS	AMPERES	│

30A/3P/NF NEMA-4X

44,46,48

*	
Holste & Associates, Inc. Consulting Engineers - Texas Reg. F-5443 6671 Southwest Frwy., Suite 850 Houston, Texas 77074 (713) 995-1351 www.holstemep.com	

ELECTRICAL KITCHEN PLAN

SCALE: 1/4" = 1'-0"

-LK-9

LK-22,24,26 4#1, 1#6GND., 1 1/2"C.

KITCHEN 103

Г		
I'		
	MA	
- 1		
- 1		
- 1	0	
- 1		
- 1		
- 1		
- 1	5//	
- 1		
- 1		
- 1	ALUISINE CULSINE CULSINE CALINE	
- 1	E 6	
- 1		
- 1	5	
- 1		
- 1	20	
- 1	B	
- 1	550	
- 1		
- 1	\Rightarrow	

GUADALUPANA RESTAURANT

PROJECT NAME

CONSULTANTS

HARRELL

9575 Katy Frwy., #200 Houston, Texas 77024 tel: 713.722.7071 fax: 713.722.7072

HOLSTE & ASSOCIATES MEP Engineers

ELECTRICAL
KITCHEN PLAN SHEET NAME PROJECT ADDRESS PROJECT NUMBER 20 WATERWAY THE WOODLANDS, TEXAS

SHEET NUMBER