




8 PEDESTAL MOUNTED RECEPTACLE SCALE: NONE

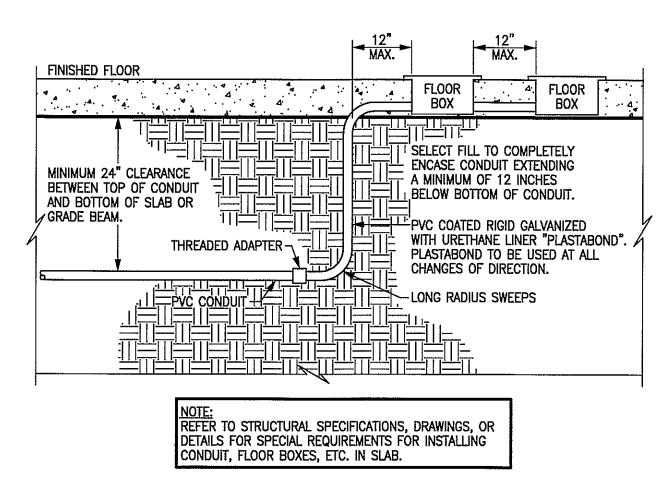


7 CONDUIT/ FLOOR BOX
SCALE: NONE

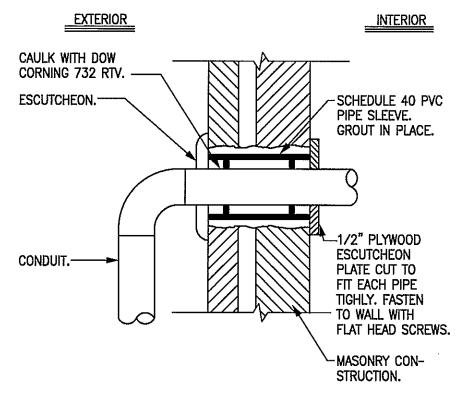


6 CONDUIT ENTRY THRU EXTERIOR WALL
SCALE: NONE

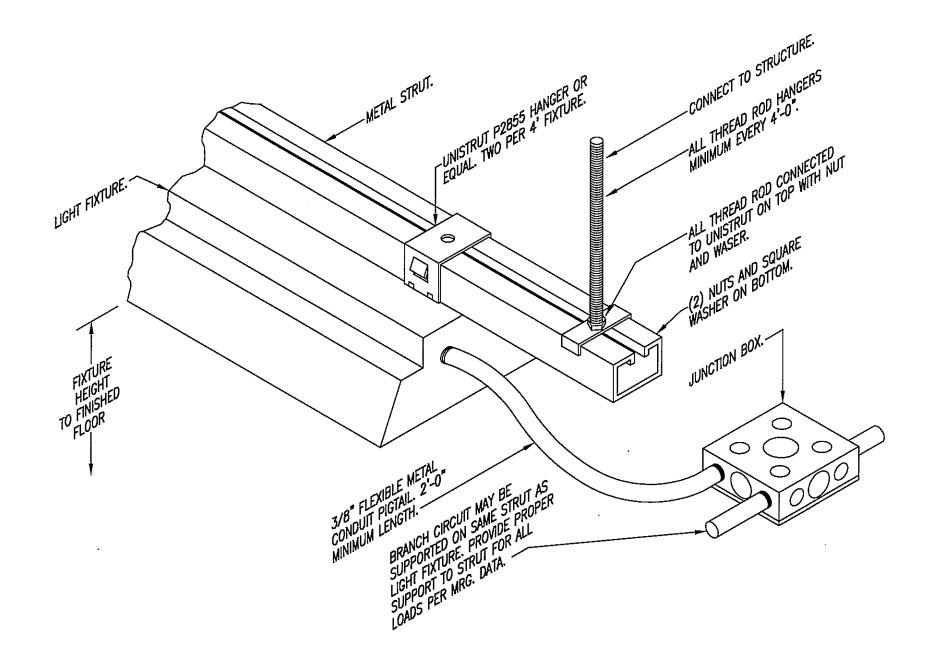


5 LIGHT FIXTURE MOUNTING DETAIL
SCALE: NONE

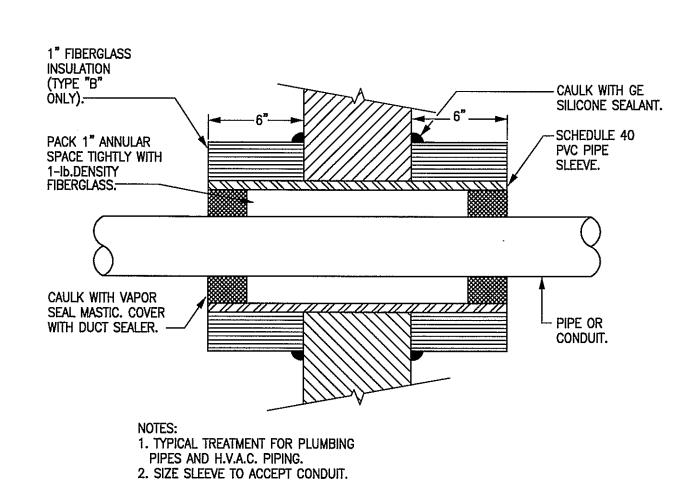


4 CONDUIT SEALANT THRU EXTERIOR WALL
SCALE: NOT TO SCALE

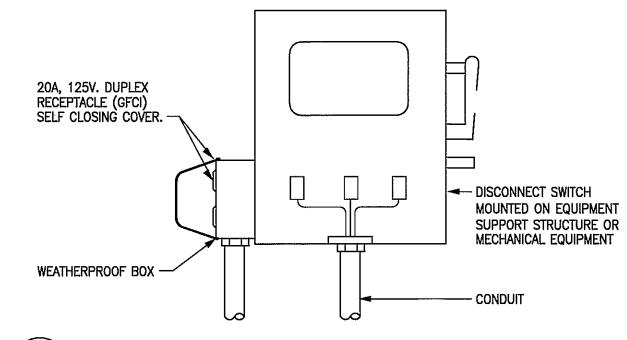

ROOF MOUNTED RECEPTACLE DETAIL
SCALE: NONE

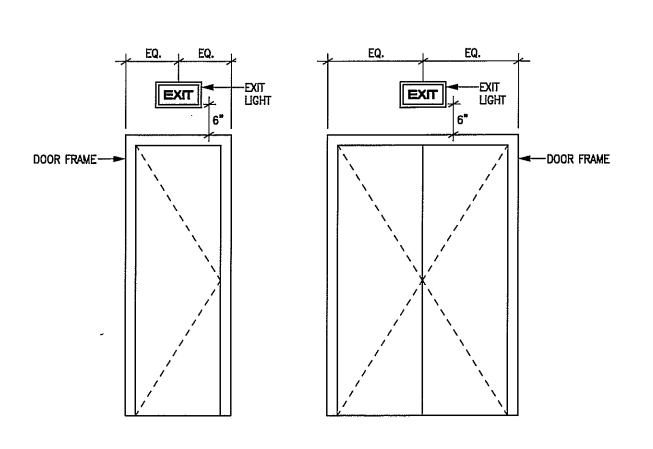

2 TYPICAL EXIT SIGN LOCATION
SCALE: NONE

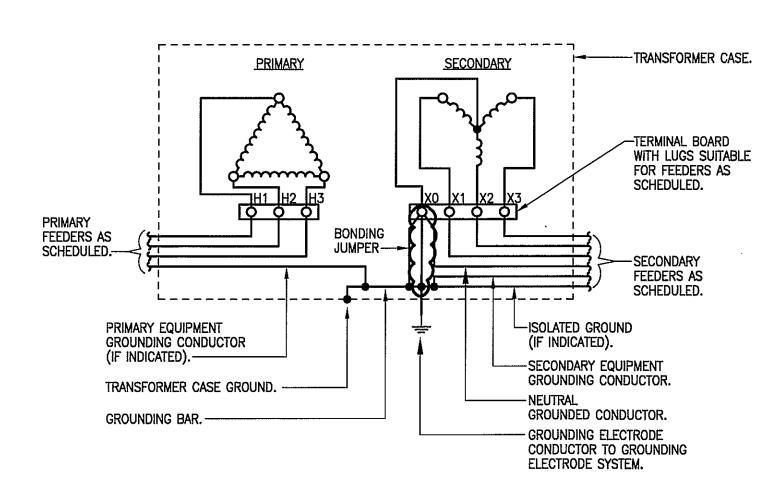

1 TRANSFORMER GROUNDING DETAIL
SCALE: NONE



ISSUE

09-10-10 ISSUED FOR PERMIT10-08-10 DBR REVIEW COMMENTS11-02-10 ISSUED FOR CONSTRUCTION

HRRELL ARCHITECTS, LP

9575 Katy Frwy., #200 Houston, Texas 77024 tel: 713.722.7071 fax: 713.722.7072

CONSULTANTS
HOLSTE & ASSOCIATES

MEP Engineers



PROJECT NAME

LUCA & LEONARDO RESTAURANT

LEONARDC

PROJECT ADDRESS

20 WATERWAY
THE WOODLANDS, TEXAS

PROJECT NUMBER

ELECTRICAL DETAILS

SHEET NUMBER

E5.00